


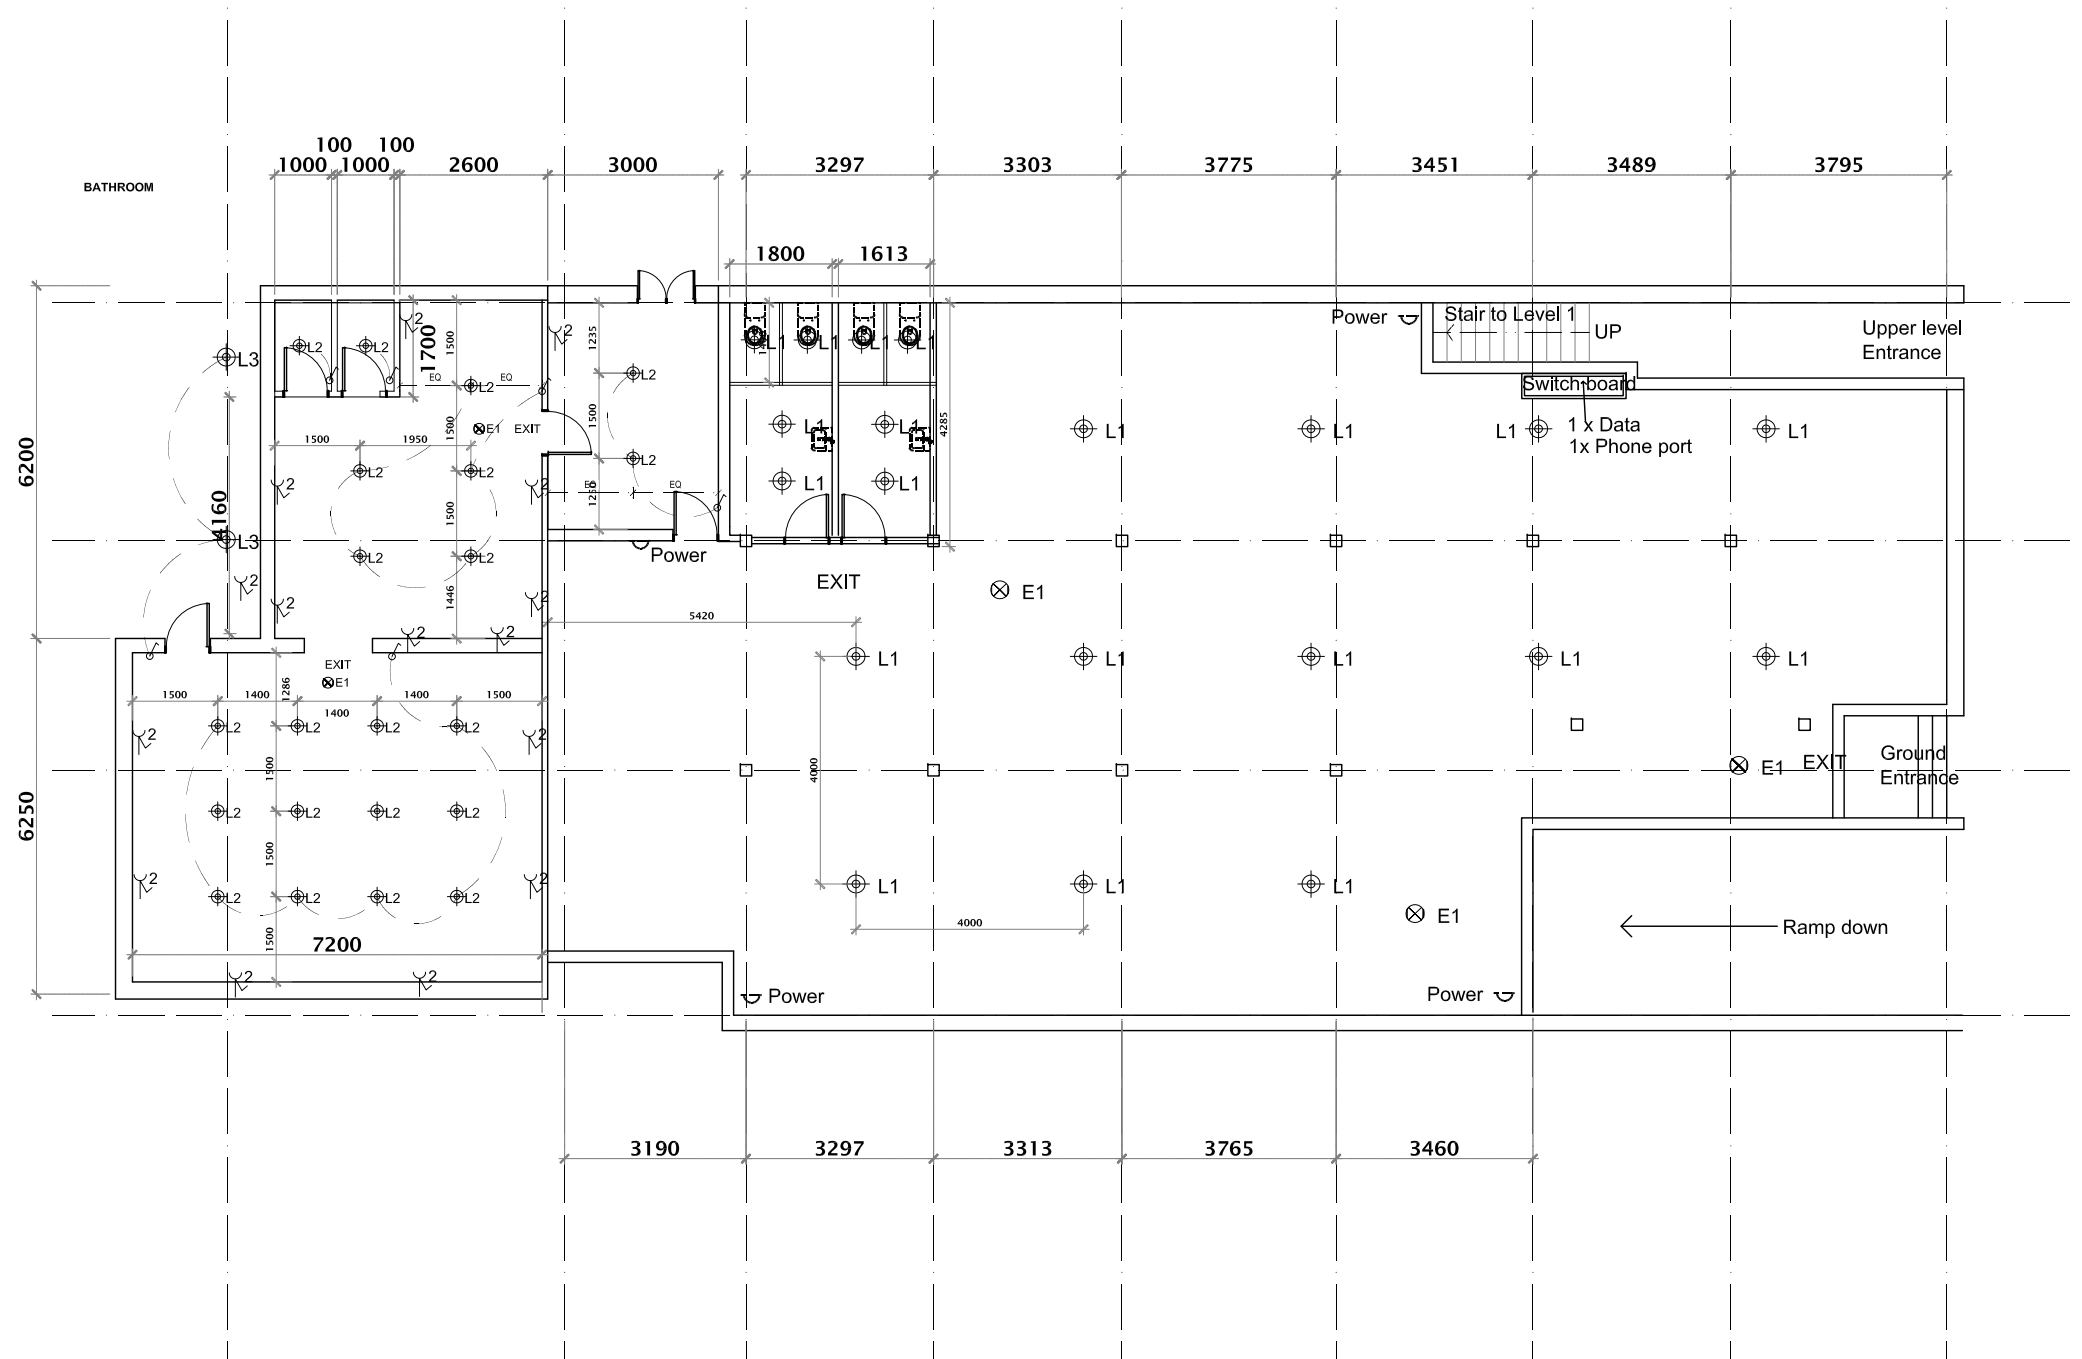

- ⊕ L1 Down light FIRE RATED
- ⊕ L2 Down light
- ⊕ L3 Wall mount light
- ⌞ Wall Mount light switch
- ⌞ Power socket
- EXIT EXIT light

Lighting Plan

1:100 A3

1. Contractors to read and understand all documentation before commencing work.
2. Contractors to verify all dimensions on site
3. All construction to be in accordance with NZS 3604 2011 and approved documents and local authority requirements
4. Any changes made on site must be first verified by CP Group
5. Report all discrepancies found on site to CP Group

NOTES:
L1 : TBC

- ⊕ L1
- ⌞ Power
- ⊗ E1

JOB TITLE

9 Gore Street, Auckland

SHEET TITLE

GROUND FLOOR PLAN



SCALE 1:100